
 


SEE CONTINUATION BELOW

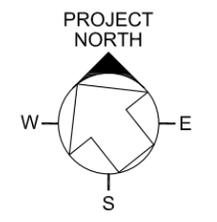

PROJECT X
CONVENTIONAL FACILITIES
PROJECT SITE & UTILITIES
PROJECT OVERVIEW SITE PLAN


PDR



DATE
JUNE 2010


PROJECT NO.
4-2-1

DRAWING NO.
PDR-101

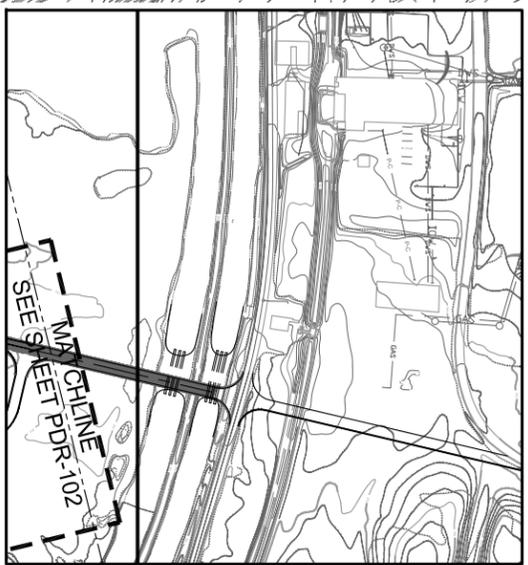



SCALE:
1" = 30'-0"

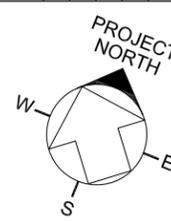

PROJECT X
CONVENTIONAL FACILITIES
PROJECT SITE & UTILITIES
FUTURE EXPERIMENTAL AREA

PDR
 Fermilab

U.S. DEPARTMENT OF ENERGY

DATE

JUNE 2010

PROJECT NO.


4-2-1

DRAWING NO.

PDR-111

TO WILSON HALL

TO PROJECT X

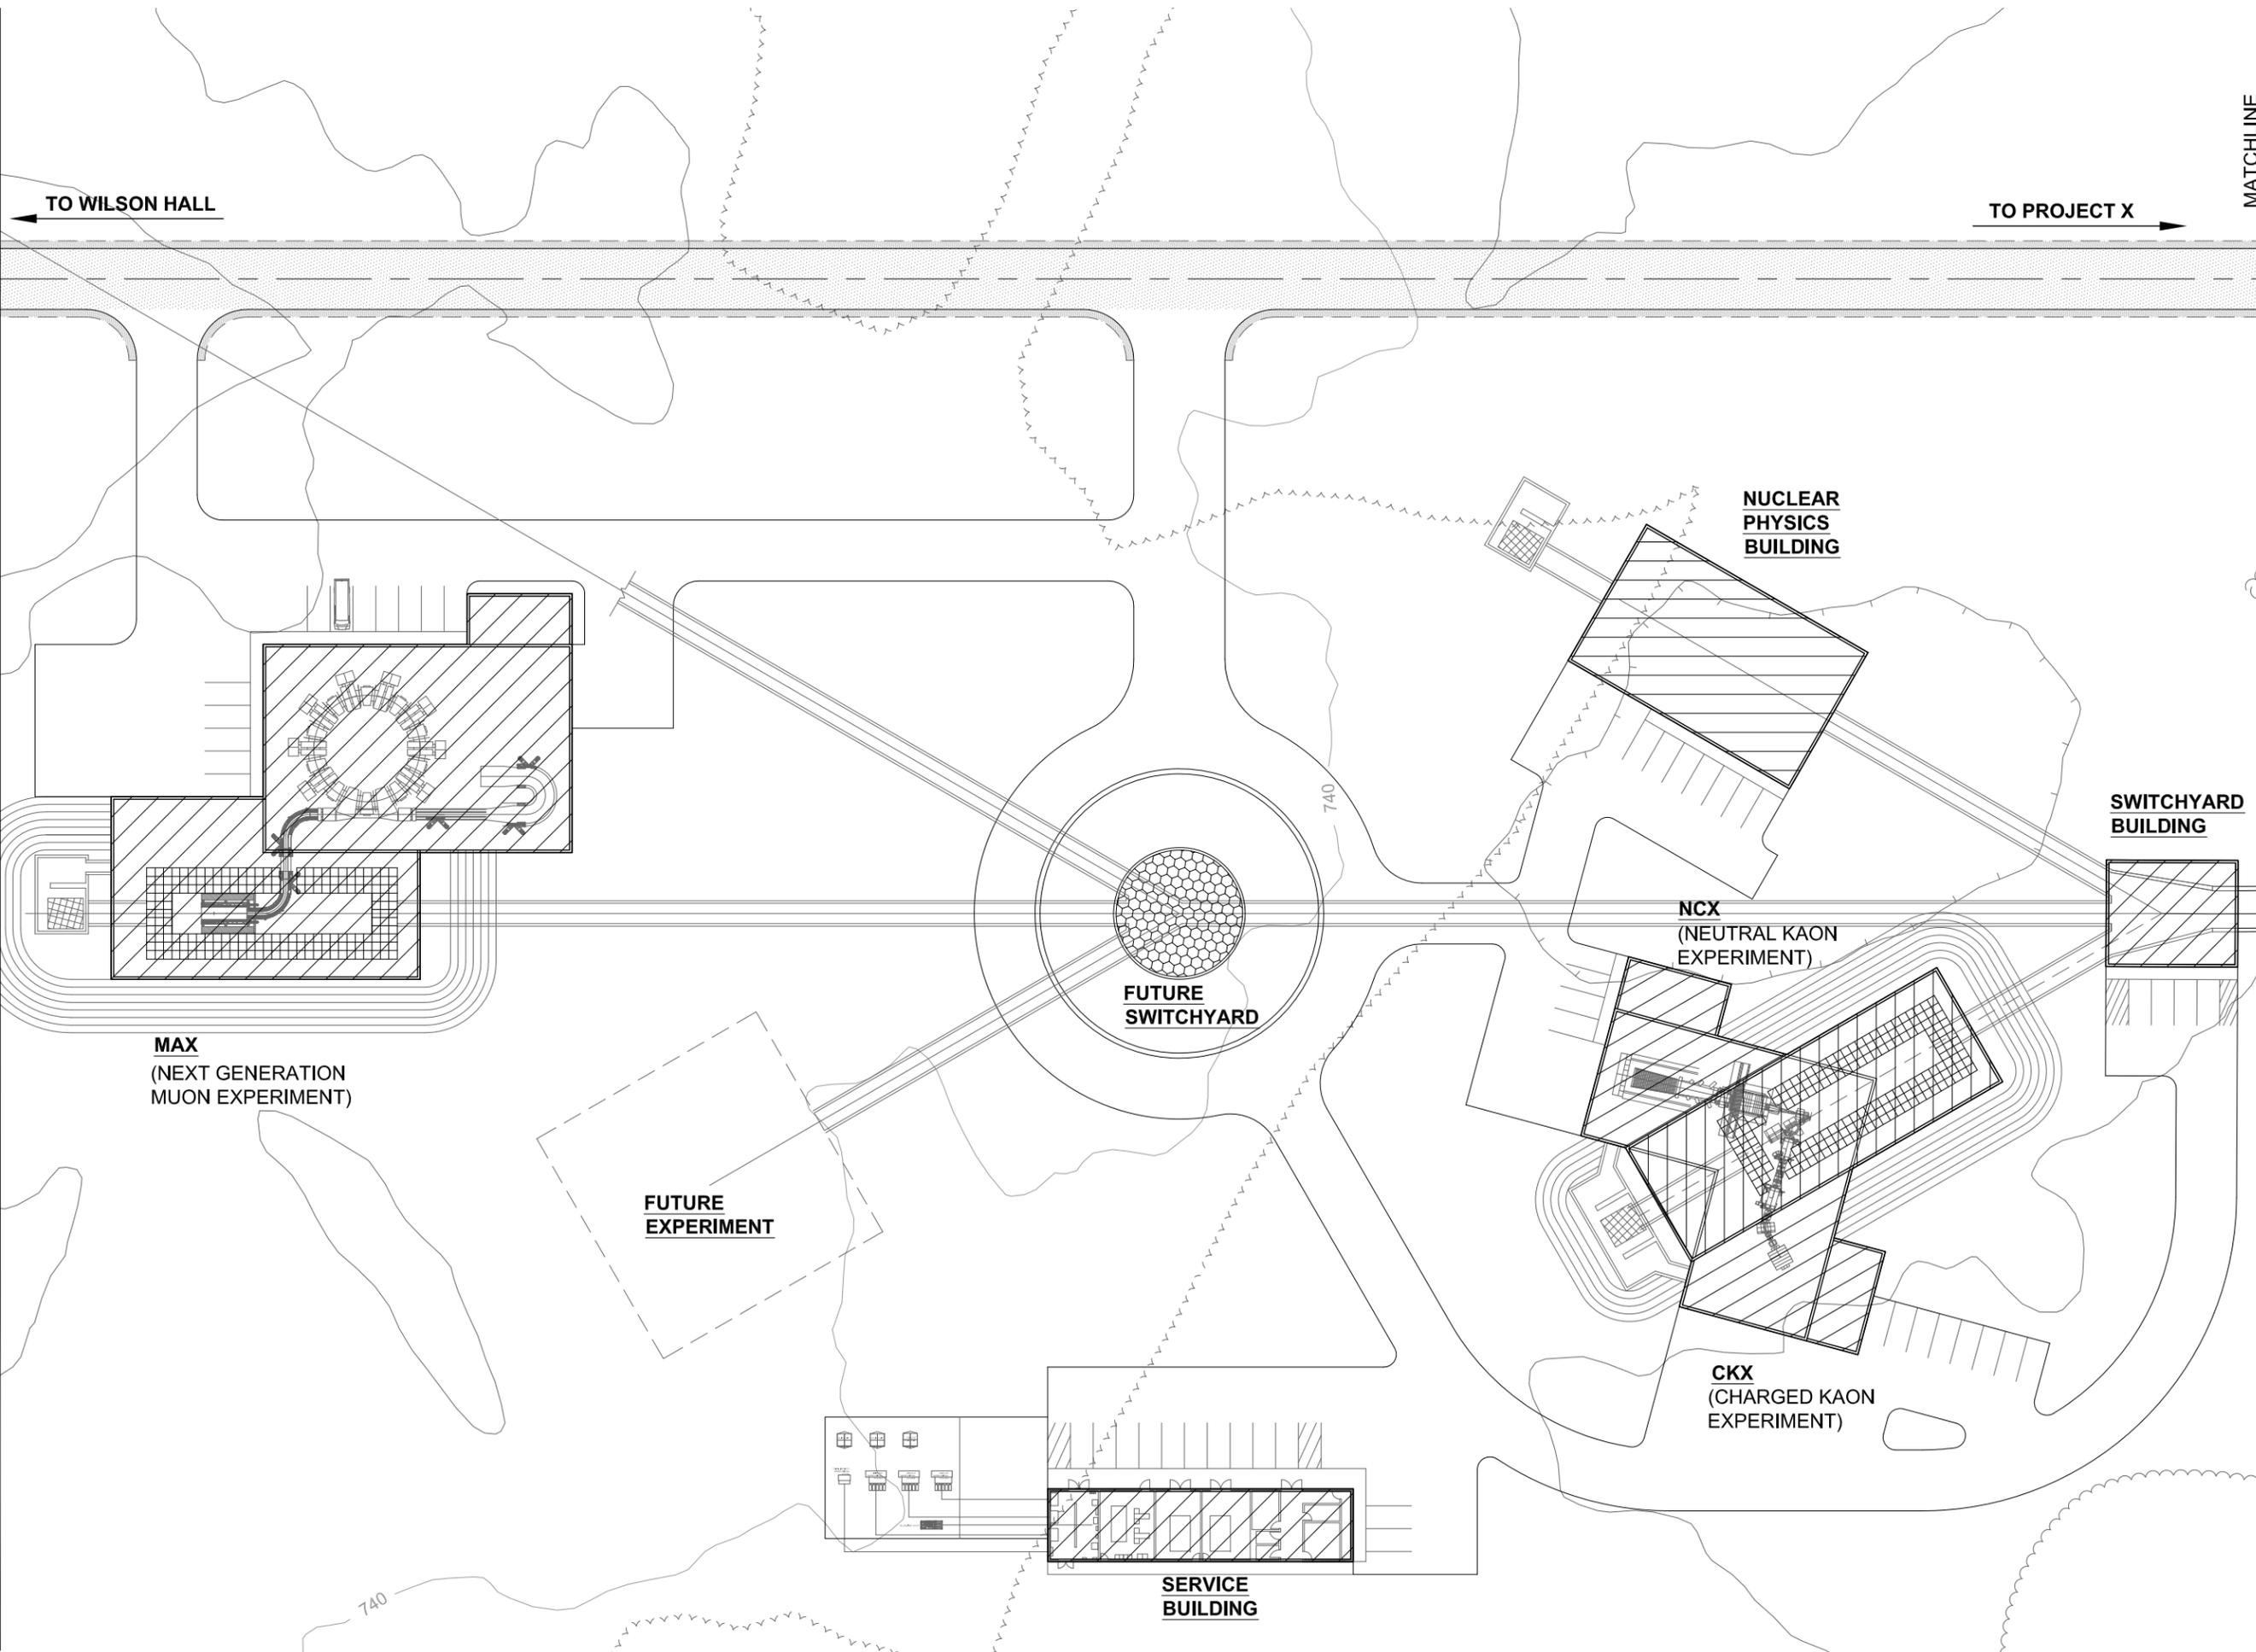

MAX
(NEXT GENERATION
MUON EXPERIMENT)

**FUTURE
EXPERIMENT**

**FUTURE
SWITCHYARD**

**SERVICE
BUILDING**

**NUCLEAR
PHYSICS
BUILDING**


NCX
(NEUTRAL KAON
EXPERIMENT)

CKX
(CHARGED KAON
EXPERIMENT)

**SWITCHYARD
BUILDING**

740

740

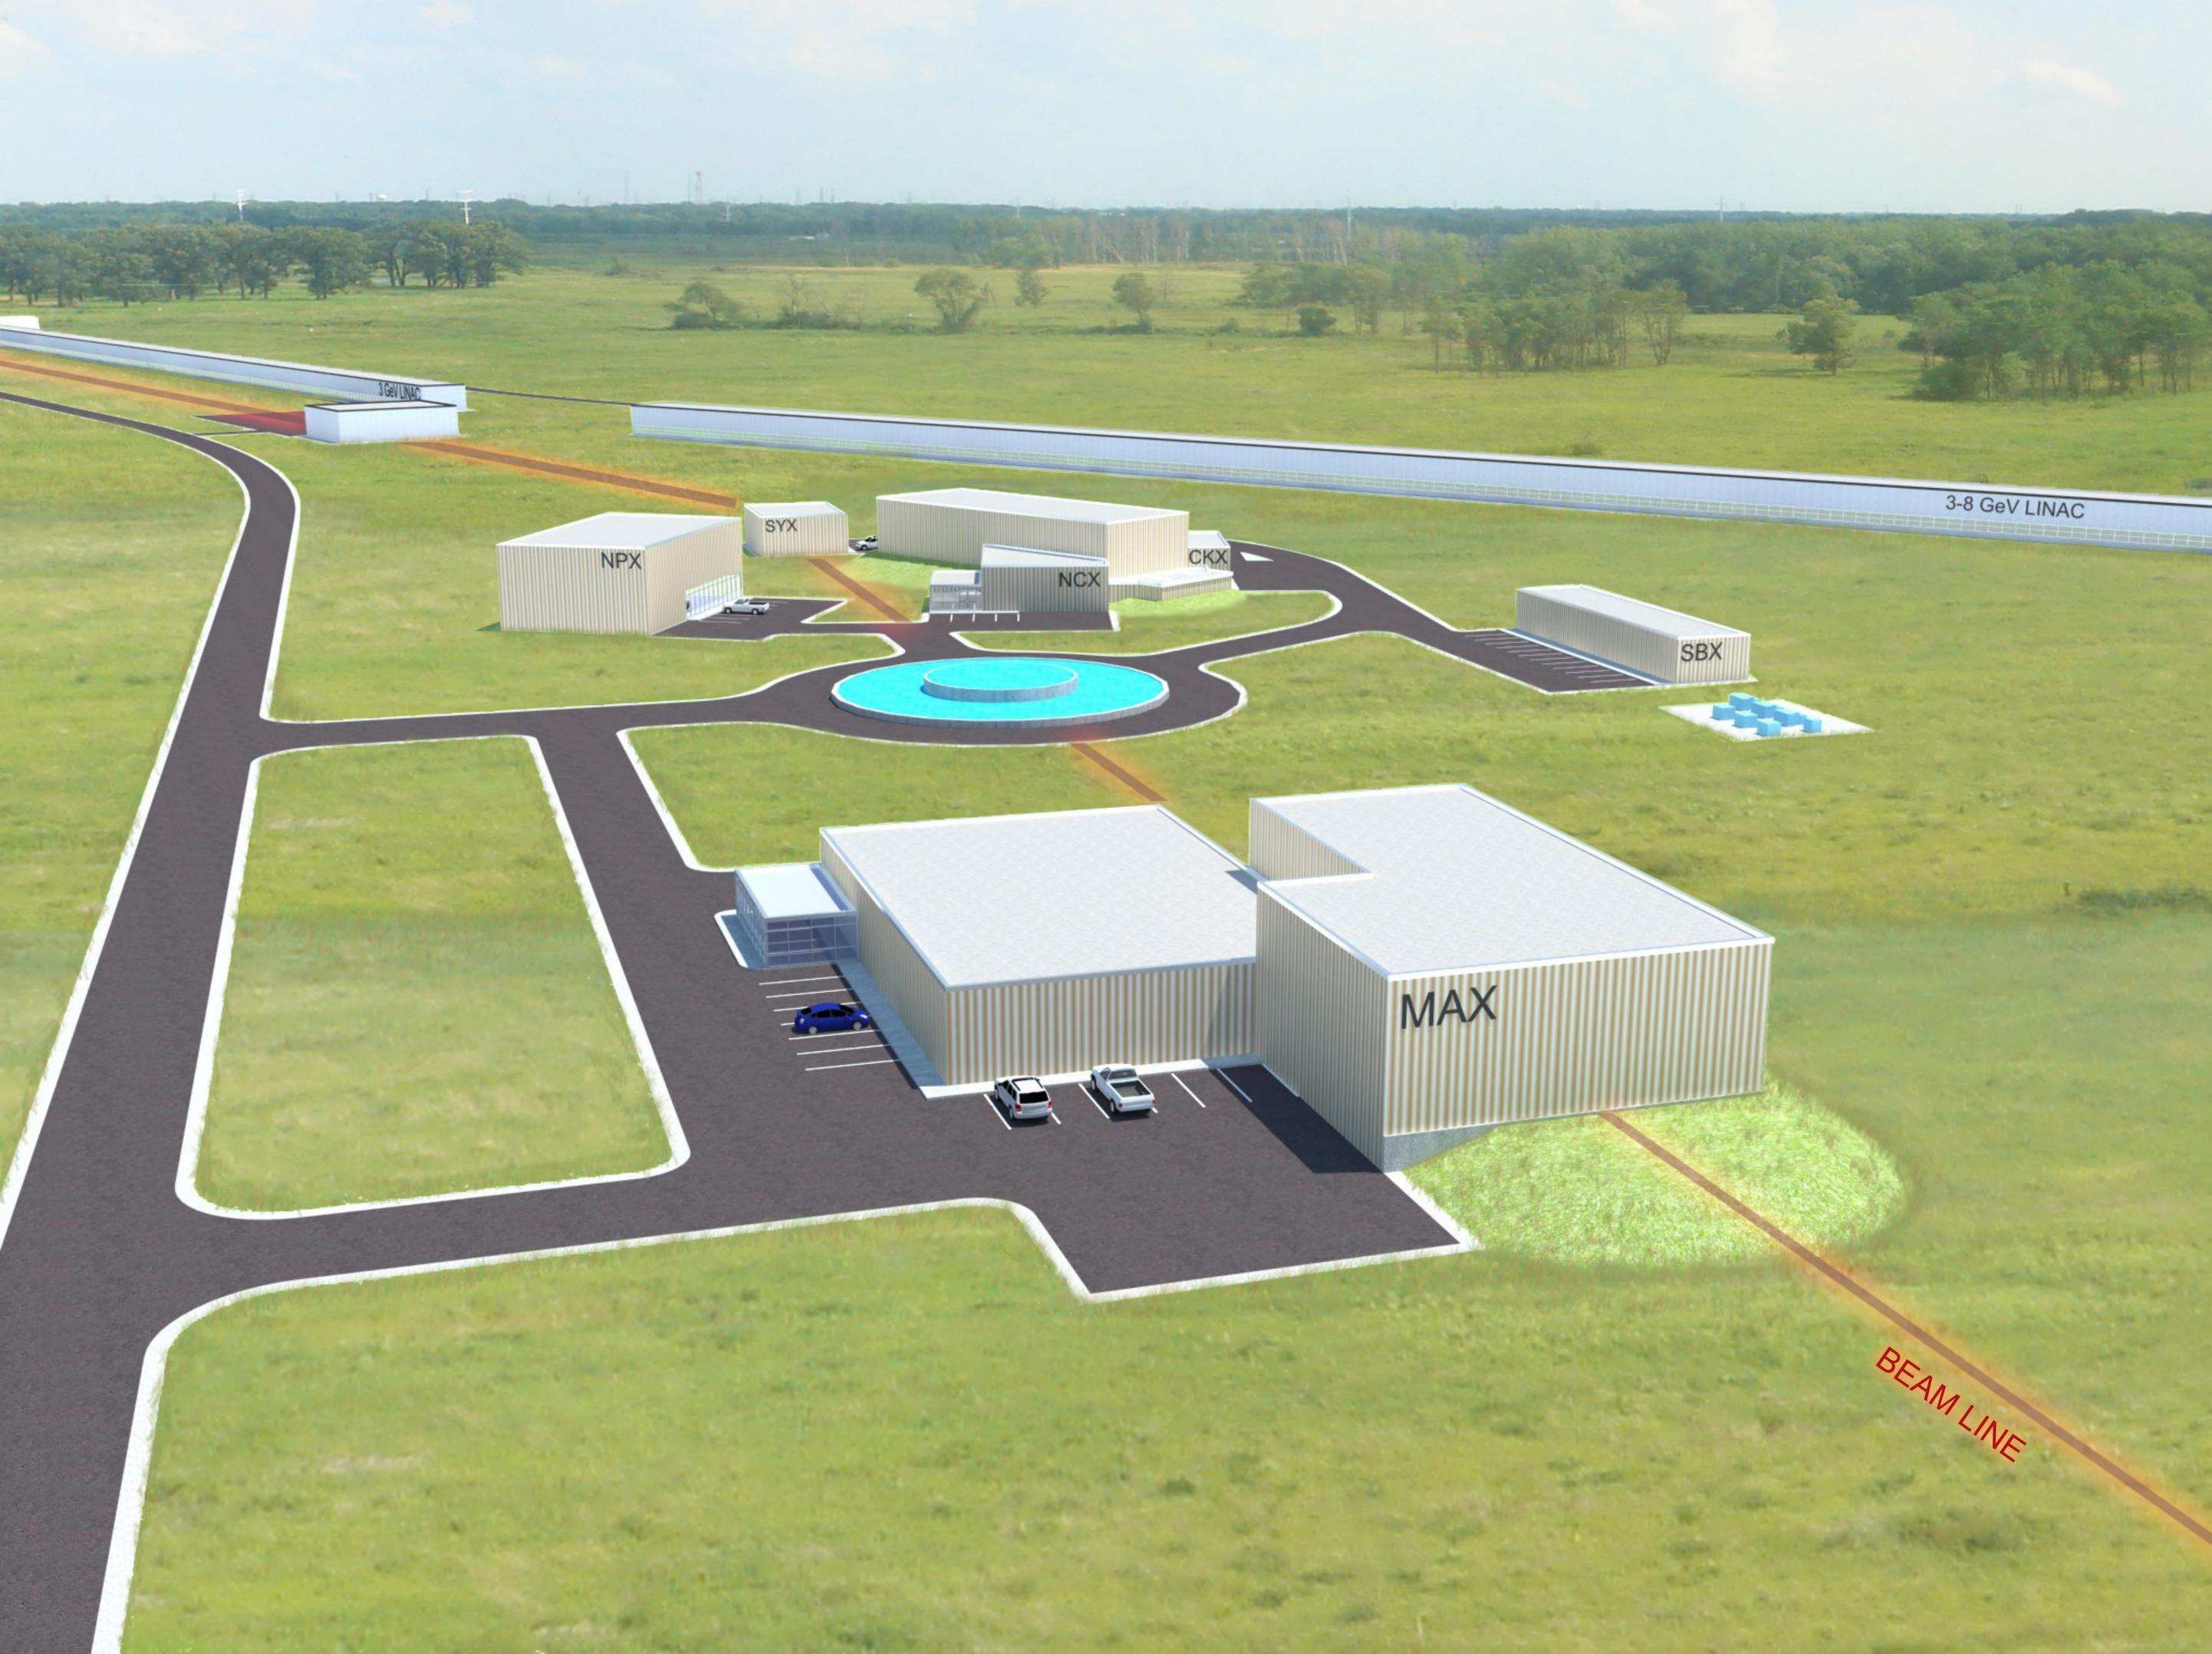

3 GeV LINAC

3-8 GeV LINAC

NPX

SYX


NCX

CKX

SBX

MAX

BEAM LINE

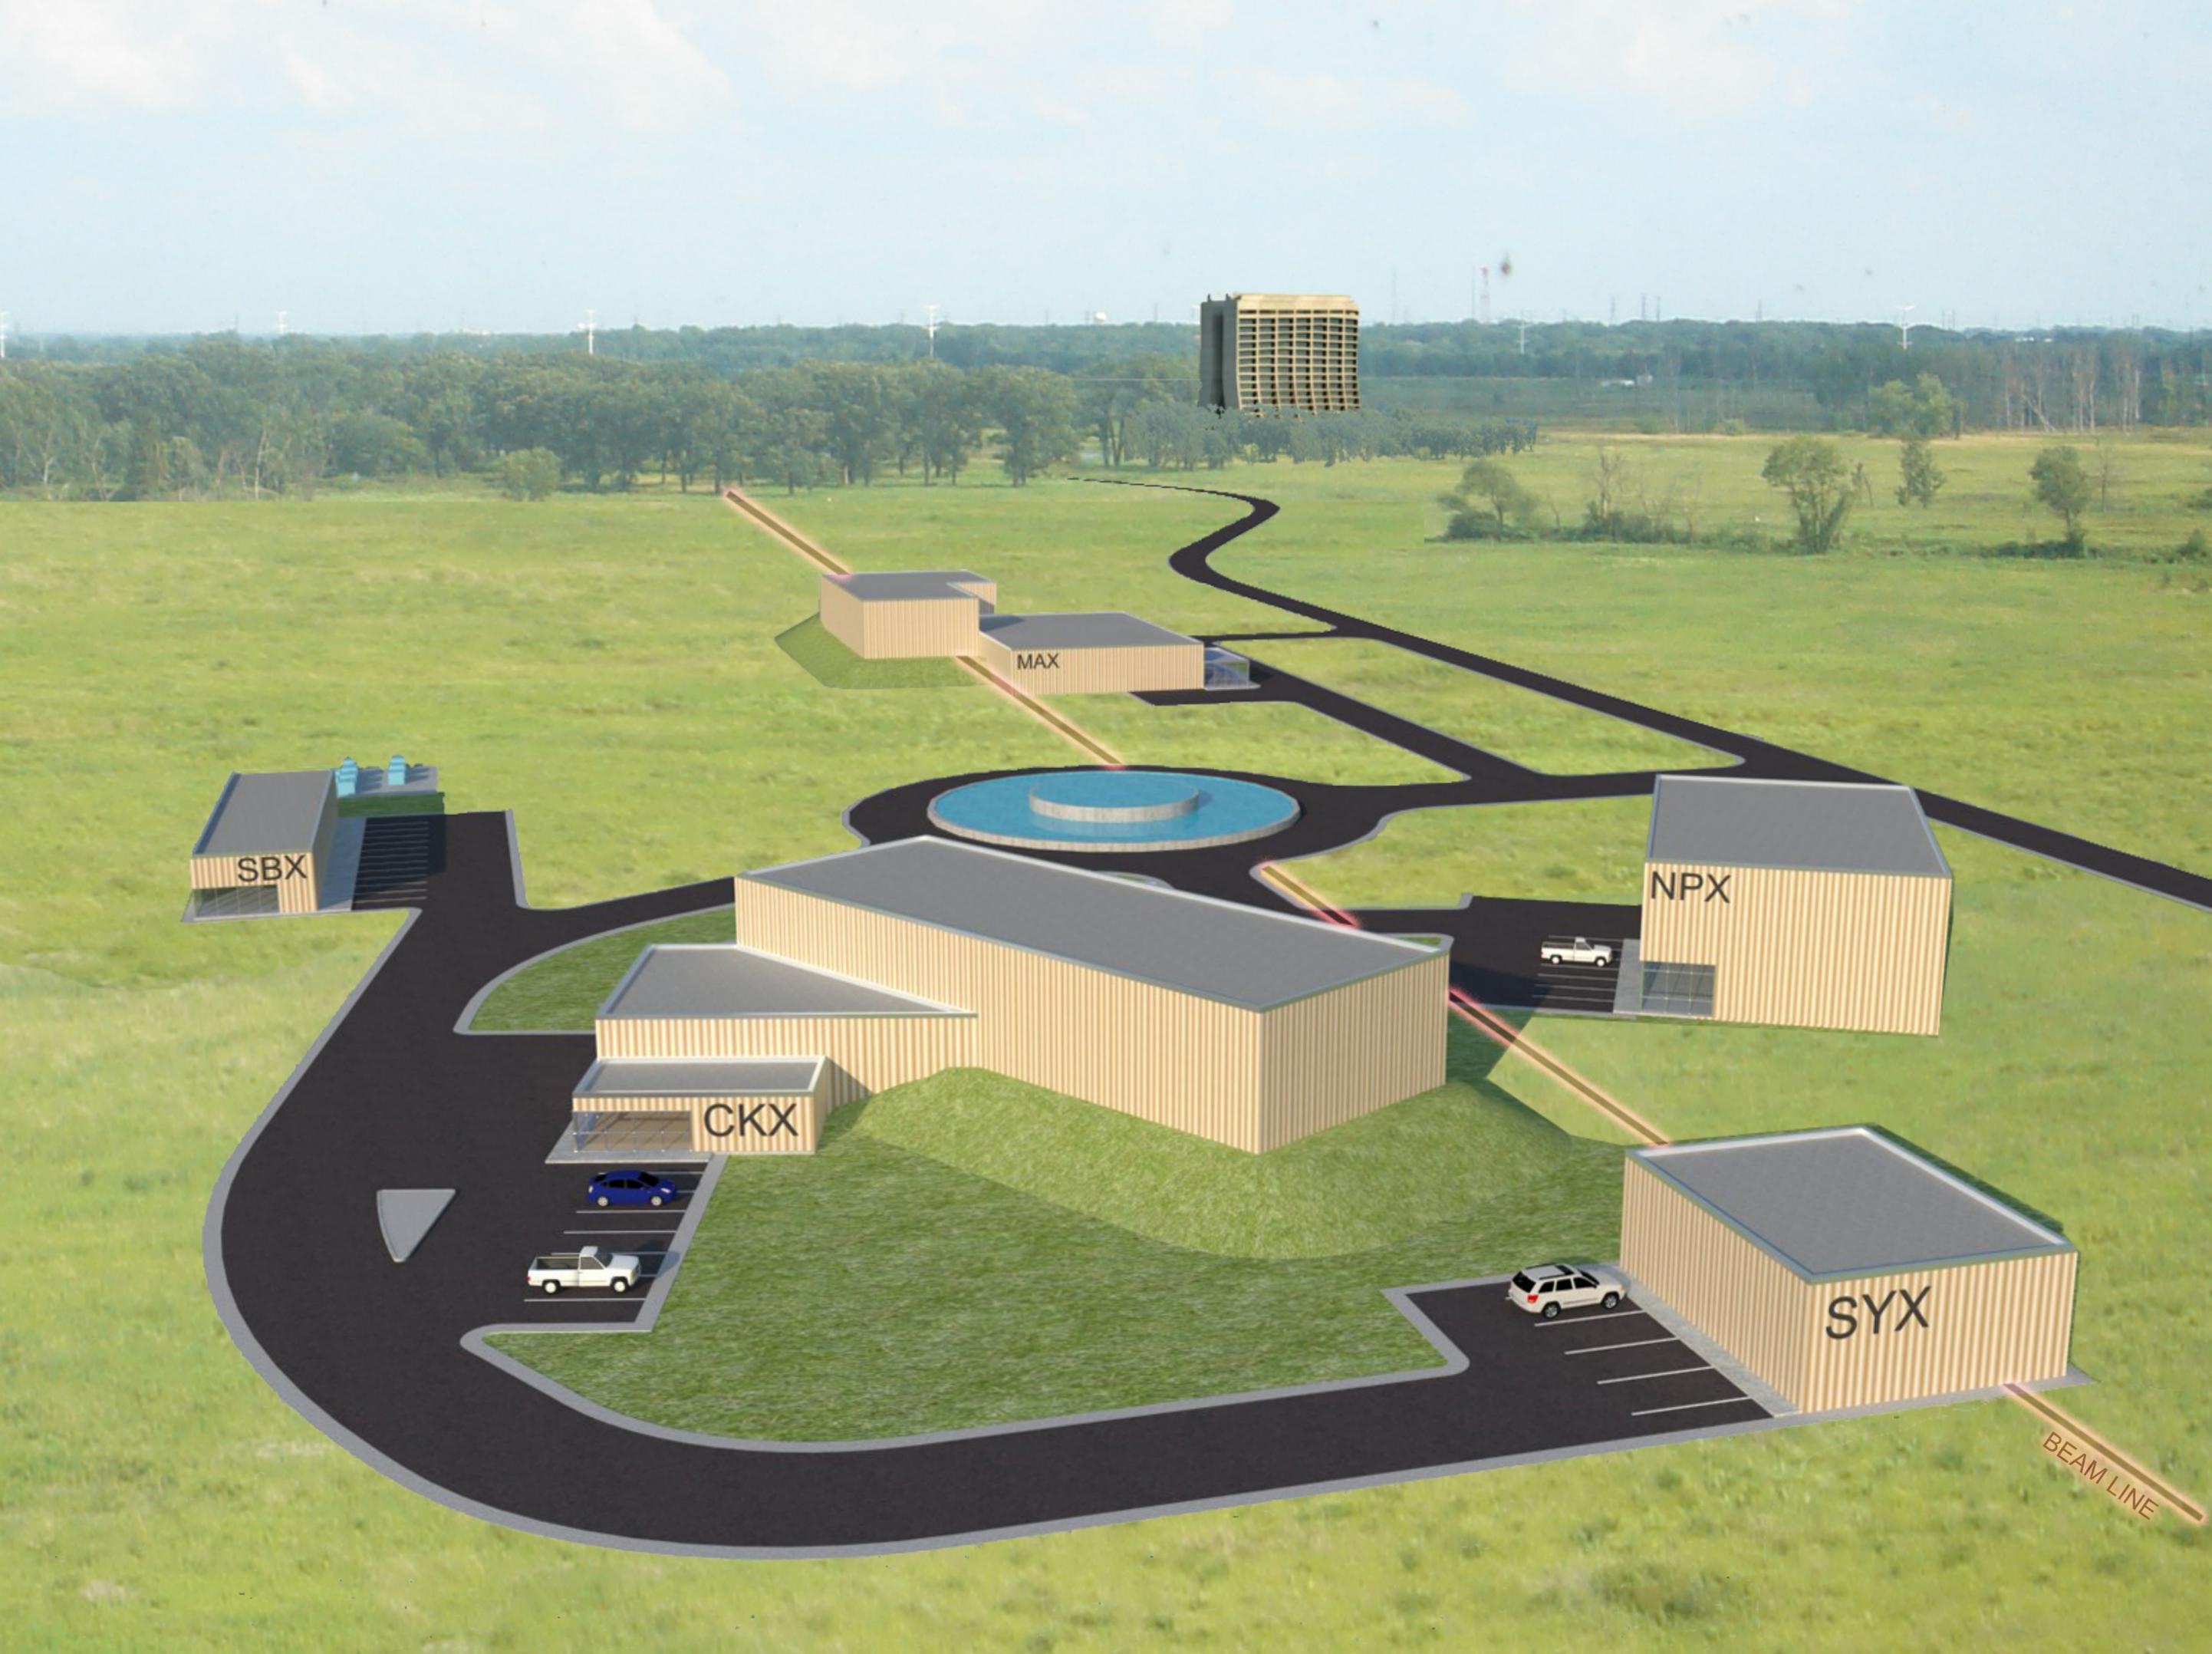

SBX

MAX

CKX

NPX

SYX

BEAM LINE